

TCT ĐIỆN LỰC DẦU KHÍ VIỆT NAM - CTCP
CÔNG TY CỔ PHẦN
ĐIỆN LỰC DẦU KHÍ NHƠN TRẠCH 2

CỘNG HÒA XÃ HỘI CHỦ NGHĨA VIỆT NAM
Độc Lập – Tự do – Hạnh phúc

Đồng Nai, ngày tháng năm 2026

Số: /CPNT2-TCHC

V/v: Xin báo giá gói thầu Dịch vụ lên ý tưởng
phối cảnh 3D và hỗ trợ xây dựng phạm vi
công việc công tác cải tạo một số khu vực,
phòng họp tại tòa nhà Hành chính.

Kính gửi: Các nhà thầu tham dự chào giá lập dự toán

Hiện nay, Công ty Cổ phần Điện lực Dầu khí Nhơn Trạch 2 (PVPower NT2) đang xây dựng dự toán gói thầu “Dịch vụ lên ý tưởng phối cảnh 3D và hỗ trợ xây dựng phạm vi công việc công tác cải tạo một số khu vực, phòng họp tại tòa nhà Hành chính” theo chi tiết bản vẽ mặt bằng đính kèm. Đề nghị Quý Công ty xem xét khảo sát và gửi báo giá cho PVPower NT2 theo thông tin như sau:

- Hình thức gửi báo giá: gửi trực tiếp, gửi qua đường bưu điện hoặc bằng fax/Email;
- Thông tin tiếp nhận báo giá: Công ty Cổ phần Điện lực Dầu khí Nhơn Trạch 2 - Ấp Phước Khánh, xã Đại Phước, TP. Đồng Nai; Điện thoại: 0251 2225899; Fax : 0251 2225897; Email: vanthu@pvnt2.com.vn.
- Thời gian tiếp nhận báo giá: trước 16h00 ngày 15/10/2026.

Trân trọng./.

Nơi nhận:

- Như trên;
- GD (thay b/c);
- P.TM-TTĐ, P.TCKT;
- Lưu VT, P.TCHC.

Đính kèm:

Bản vẽ mặt bằng

KT. GIÁM ĐỐC
PHÓ GIÁM ĐỐC



Nguyễn Thị Hà


UYC XX XX XX
 01: FOR THE SPACE BELOW FALSE FLOOR
 02: FOR FINISHED FLOOR LEVEL
 03: FOR THE SPACE ABOVE SUSPENDED CEILING
 ETC.: FOR MULTI STOREY BUILDING (CONT.)

ROOM No
 FLOOR No
 NAME BUILDING

DOOR
 DOOR NUMBER
 ROOM NUMBER
 FLOOR NUMBER



- ALL DOOR SYMBOL ARE REVISED DOOR SYMBOLS

035075
 A

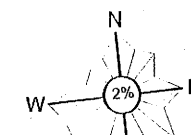

- NOTES:**
- THIS DRAWING SHALL BE READ IN CONJUNCTION WITH THE GENERAL TECHNICAL SPECIFICATION FOR CIVIL WORKS
 - FOR GENERAL NOTES, REFER TO DRAWINGS NT2-L4-C-UZ.50-001002 AND FOLLOWS.
 - ALL DIMENSIONS IN MILLIMETERS (MM)
 - ALL ELEVATIONS AND CO-ORDINATES ARE IN METERS (M)
 - BOUNDARY CO-ORDINATE AND LEVELS TO BE CONFIRMED PRIOR TO CONSTRUCTION.
 - ALL DIMENSION TO BE CONFIRMED PRIOR TO CONSTRUCTION.
 - INTERIOR 3D AND DETAIL LAYOUT ARE SHOP DRAWINGS TO BE SUBMITTED TO OWNER BEFORE CONSTRUCTION.
- REFERENCE DRAWINGS:**
- 0192.10 R.C. AB.001
 - 0192.10 R.C. AB.002
 - 0192.10 R.C. AB.003
 - 0192.10 R.C. AB.004
- BUILDING LEGEND:**
- UYC ADMINISTRATION BUILDING
 MAIN PLANT AREA
 +2.483 HON DAU = -0.300m GROUND LEVEL
 +2.733 HON DAU = ±0.00m BUILDING FINISHED FLOOR LEVEL

KEY PLAN

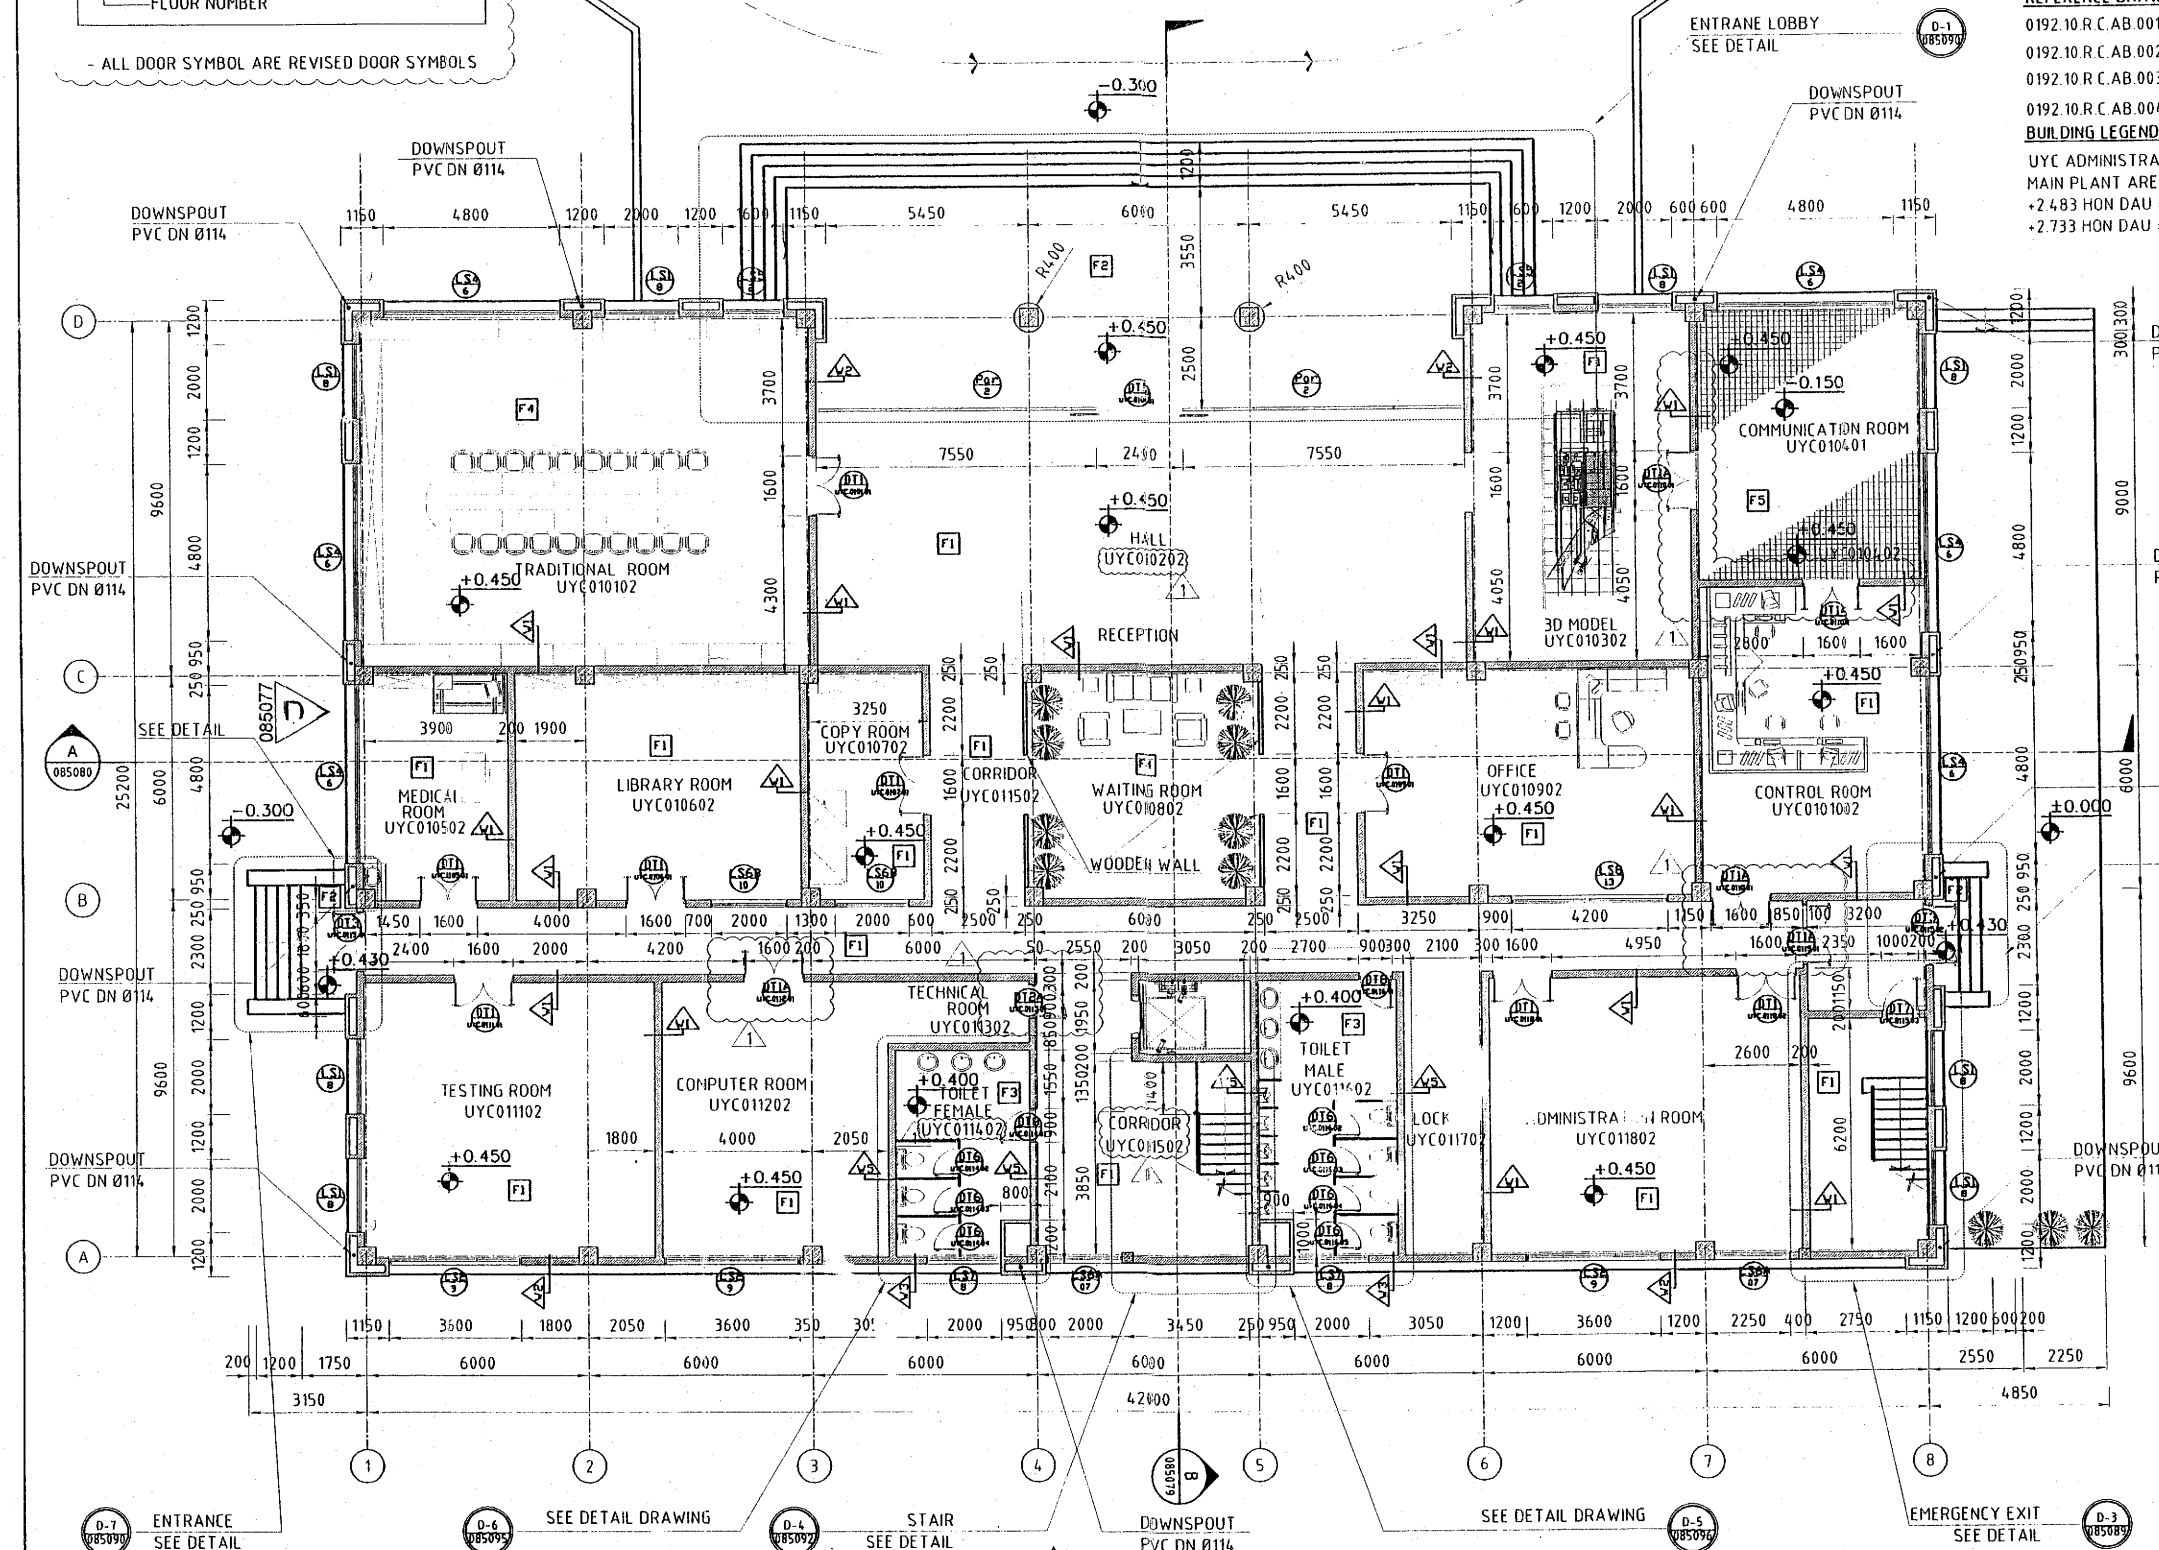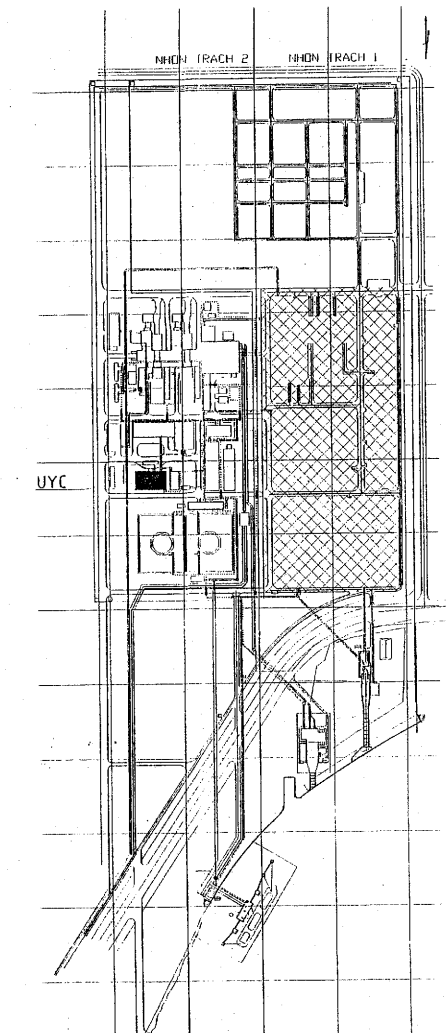

APPROVED BY PMC

RECEIVED
 REVISION
 NO.
 DATE

APPROVAL STATUS

REVIEWED BY: A. SIVIERE
 SIGNATURE: [Signature]
 DATE: 13 OCT 2010
 PROJECT MANAGER:

LEGEND

S.O.P SET OUT POINT

- FALSE FLOOR 600x600
- CERAMIC TILES NON-SLIP 250x250
- BRICK WALL
- CARPET
- EXTERIOR AND INTERIOR HOUSE PAINT LIGHT - YELLOW

APPROVED FOR CONSTRUCTION BY PVC NT2-FMB

Approved by: Name: B.Q. CUONG Sign: [Signature] Date: 27 SEP 2010

Discipline Engineer: [Signature]

Engineering Manager: MARTIN REID Sign: [Signature]

Project Manager: N.H. HIEU Sign: [Signature]

DRAWING STATUS: (FOR APPROVAL, REFERENCE, CONSTRUCTION, AS-BUILT)

REV.	DATE	DESCRIPTION	DRAWN	CHKD	APPD
1	28-08-10	FOR CONSTRUCTION	NAT	NCC	TJ
0	21-07-10	FOR CONSTRUCTION	NAT	NCC	TJ
C	14-04-10	FOR APPROVAL	NAT	NCC	TJ
B	26-03-10	FOR APPROVAL GENERAL LAYOUT	NAT	NCC	TJ
A	05-03-10	FOR APPROVAL GENERAL LAYOUT	NAT	NCC	TJ

PROJECT: NHON TRACH 2 - 750MW COMBINED CYCLE POWER PLANT PROJECT

OWNER: PETRO VIETNAM NHON TRACH 2 POWER JOINT STOCK COMPANY

CONSULTANT: C. PÖYRY

EPC CONTRACTOR: LILAMA - PVC CONSORTIUM

CONSTRUCTION: FICHTNER GmbH & Co. KG, CONNELL WAGNER (AURECON)

APPROVED FOR CONSTRUCTION

OWNER: [Signature] Full name: U.N. HAI

DESIGNED BY: [Signature] Full name: Do Ba Quang

DATE: 13 OCT 2010

PROJECT MANAGER: [Signature]

ADMINISTRATION BUILDING GROUND FLOOR PLAN

PROJECT NAME: NHON TRACH 2

FORMAT: A1

SCALE:

DESIGNED BY: PVE

CHECKED BY: CONNELL WAGNER

FUNCTION	NAME	SIGN	DATE	FUNCTION	NAME	SIGN	DATE
APPROVED	TJ	[Signature]	28-08-10				
CHECKED	NCC	[Signature]	28-08-10				
DRAWN	NAT	[Signature]	28-08-10				

DRAWING No: NT2-L4-C-UYC 71-085070

DATE: 11-09-10



REV: 1

GROUND FLOOR PLAN
 1/100

NOTES:

REFER TO NT2-L4-C-UYC.71-085070 FOR GENERAL NOTES

KEY PLAN

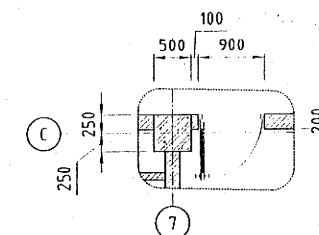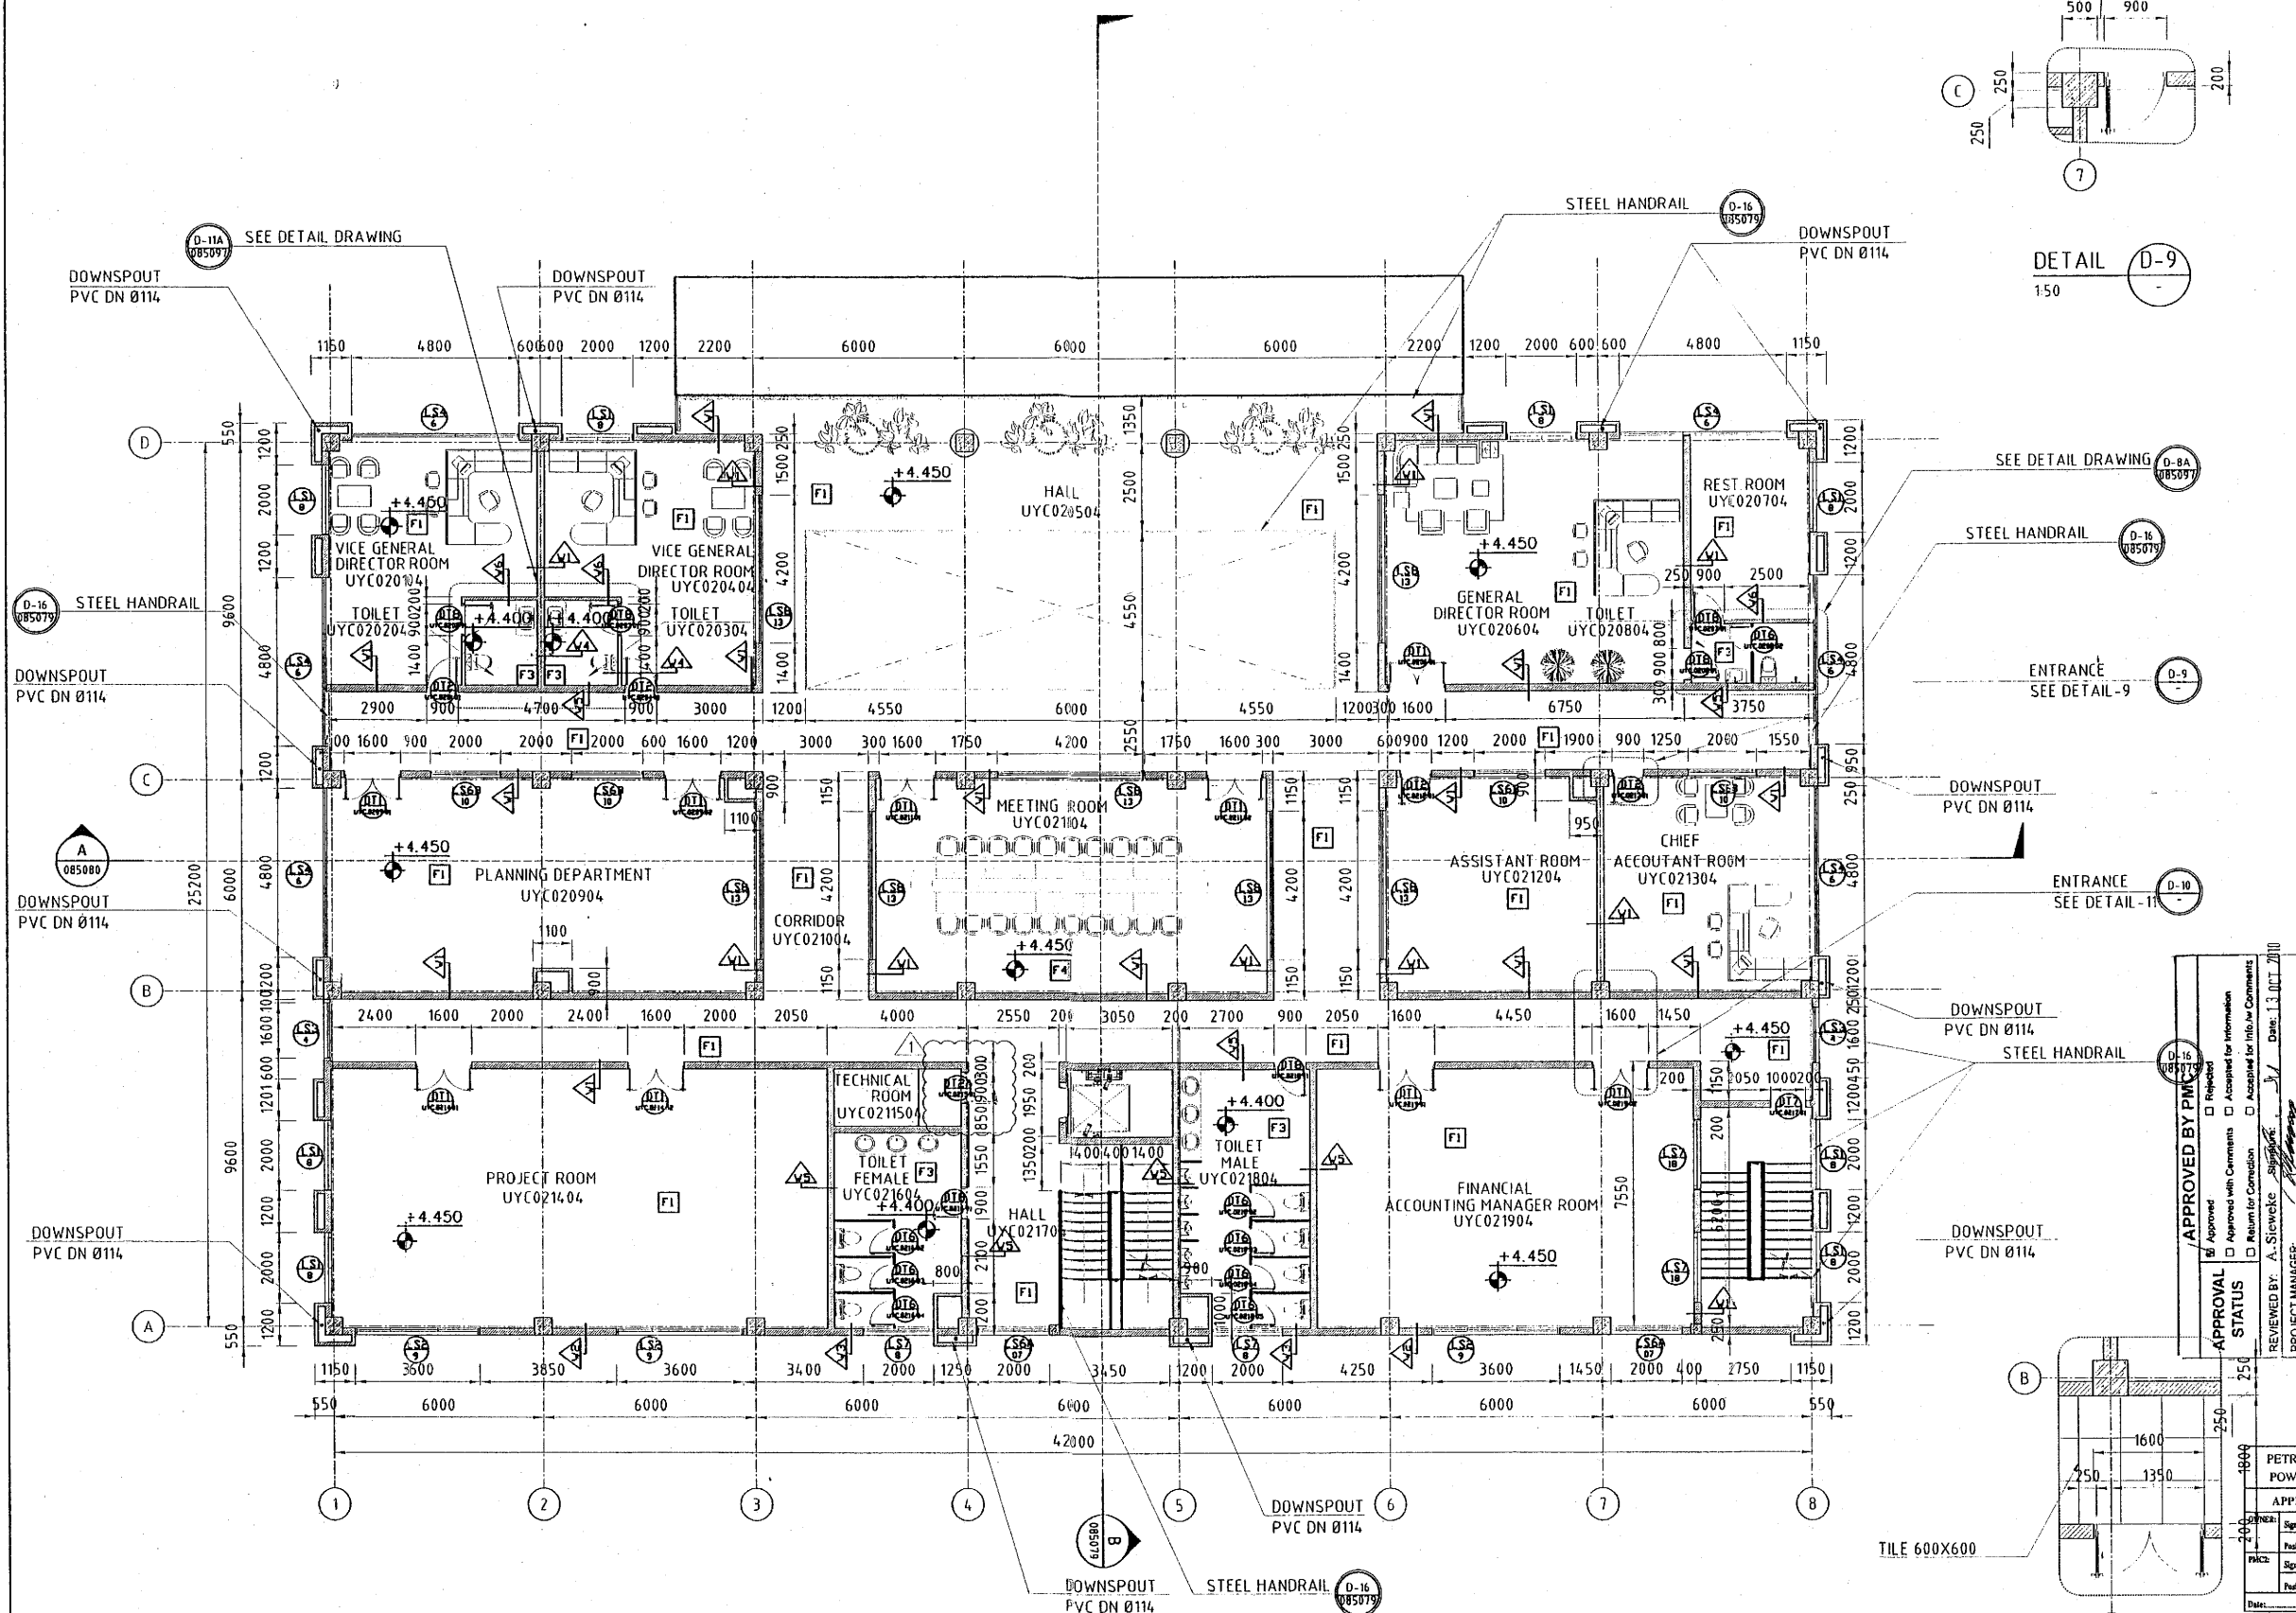

DETAIL D-9
150

SEE DETAIL DRAWING D-8A (085079)

STEEL HANDRAIL D-16 (085079)

ENTRANCE SEE DETAIL-9 D-9

DOWNSPOUT PVC DN Ø114

ENTRANCE SEE DETAIL-11 D-10

DOWNSPOUT PVC DN Ø114


STEEL HANDRAIL D-16 (085079)

DOWNSPOUT PVC DN Ø114

TILE 600X600

STEEL HANDRAIL D-16 (085079)

DETAIL D-10
150

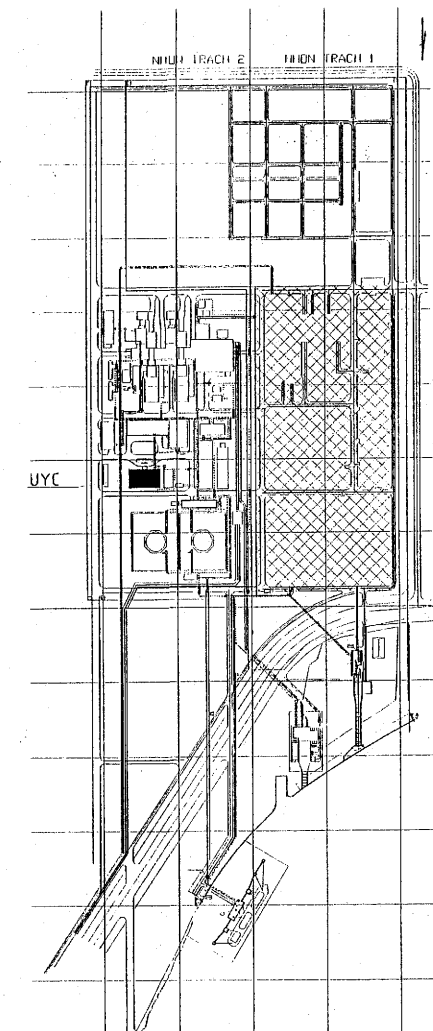

APPROVED FOR CONSTRUCTION BY PVC NT2-PMB

Approved by:	Name	Signature	Date
Discipline Engineer	B.Q. CUONG	[Signature]	21 SEP 2010
Engineering Manager	MARTIN REID	[Signature]	
Project Manager	N.H. HIEU	[Signature]	

DRAWING STATUS: (FOR APPROVAL REFERENCE, CONSTRUCTION, AS-BUILT)

REV.	DATE	DESCRIPTION	DRAWN	CHECK	APPROVED
1	28-08-10	FOR CONSTRUCTION	NAT	NCC	TJ
0	21-07-10	FOR CONSTRUCTION	NAT	NCC	TJ
C	14-04-10	FOR APPROVAL NEW LAYOUT	NAT	NCC	TJ
B	26-03-10	FOR APPROVAL GENERAL LAYOUT	NAT	NCC	TJ
A	05-03-10	FOR APPROVAL GENERAL LAYOUT	NAT	NCC	TJ

PROJECT: NHON TRACH 2 - 750MW COMBINED CYCLE POWER PLANT PROJECT

OWNER: PETRO VIETNAM NHON TRACH 2 POWER JOINT STOCK COMPANY

EPC CONTRACTOR: LILAMA - PVC CONSORTIUM

CONSULTANT: FICHTNER GmbH & Co.KG, CONNELL WAGNER (AURECON)

APPROVED FOR CONSTRUCTION

Signature: [Signature] Full name: U.N. HAI

Position: Project Manager

Date: 13 OCT 2010

PROJECT NAME: NHON TRACH 2

DESIGNED BY: PVE

CHECKED BY: CONNELL WAGNER

FUNCTION	NAME	DATE	FUNCTION	NAME	DATE
APPROVED	TJ	28-08-10			
CHECKED	NCC	28-08-10			
DRAWN	NAT	28-08-10			



DRAWING NO: NT2-L4-C-UYC.71-085071

DATE: 14-09-10

REV: 1

NOTES:
REFER TO NT2-L4-C-UYC.71-085070 FOR GENERAL NOTES

KEY PLAN

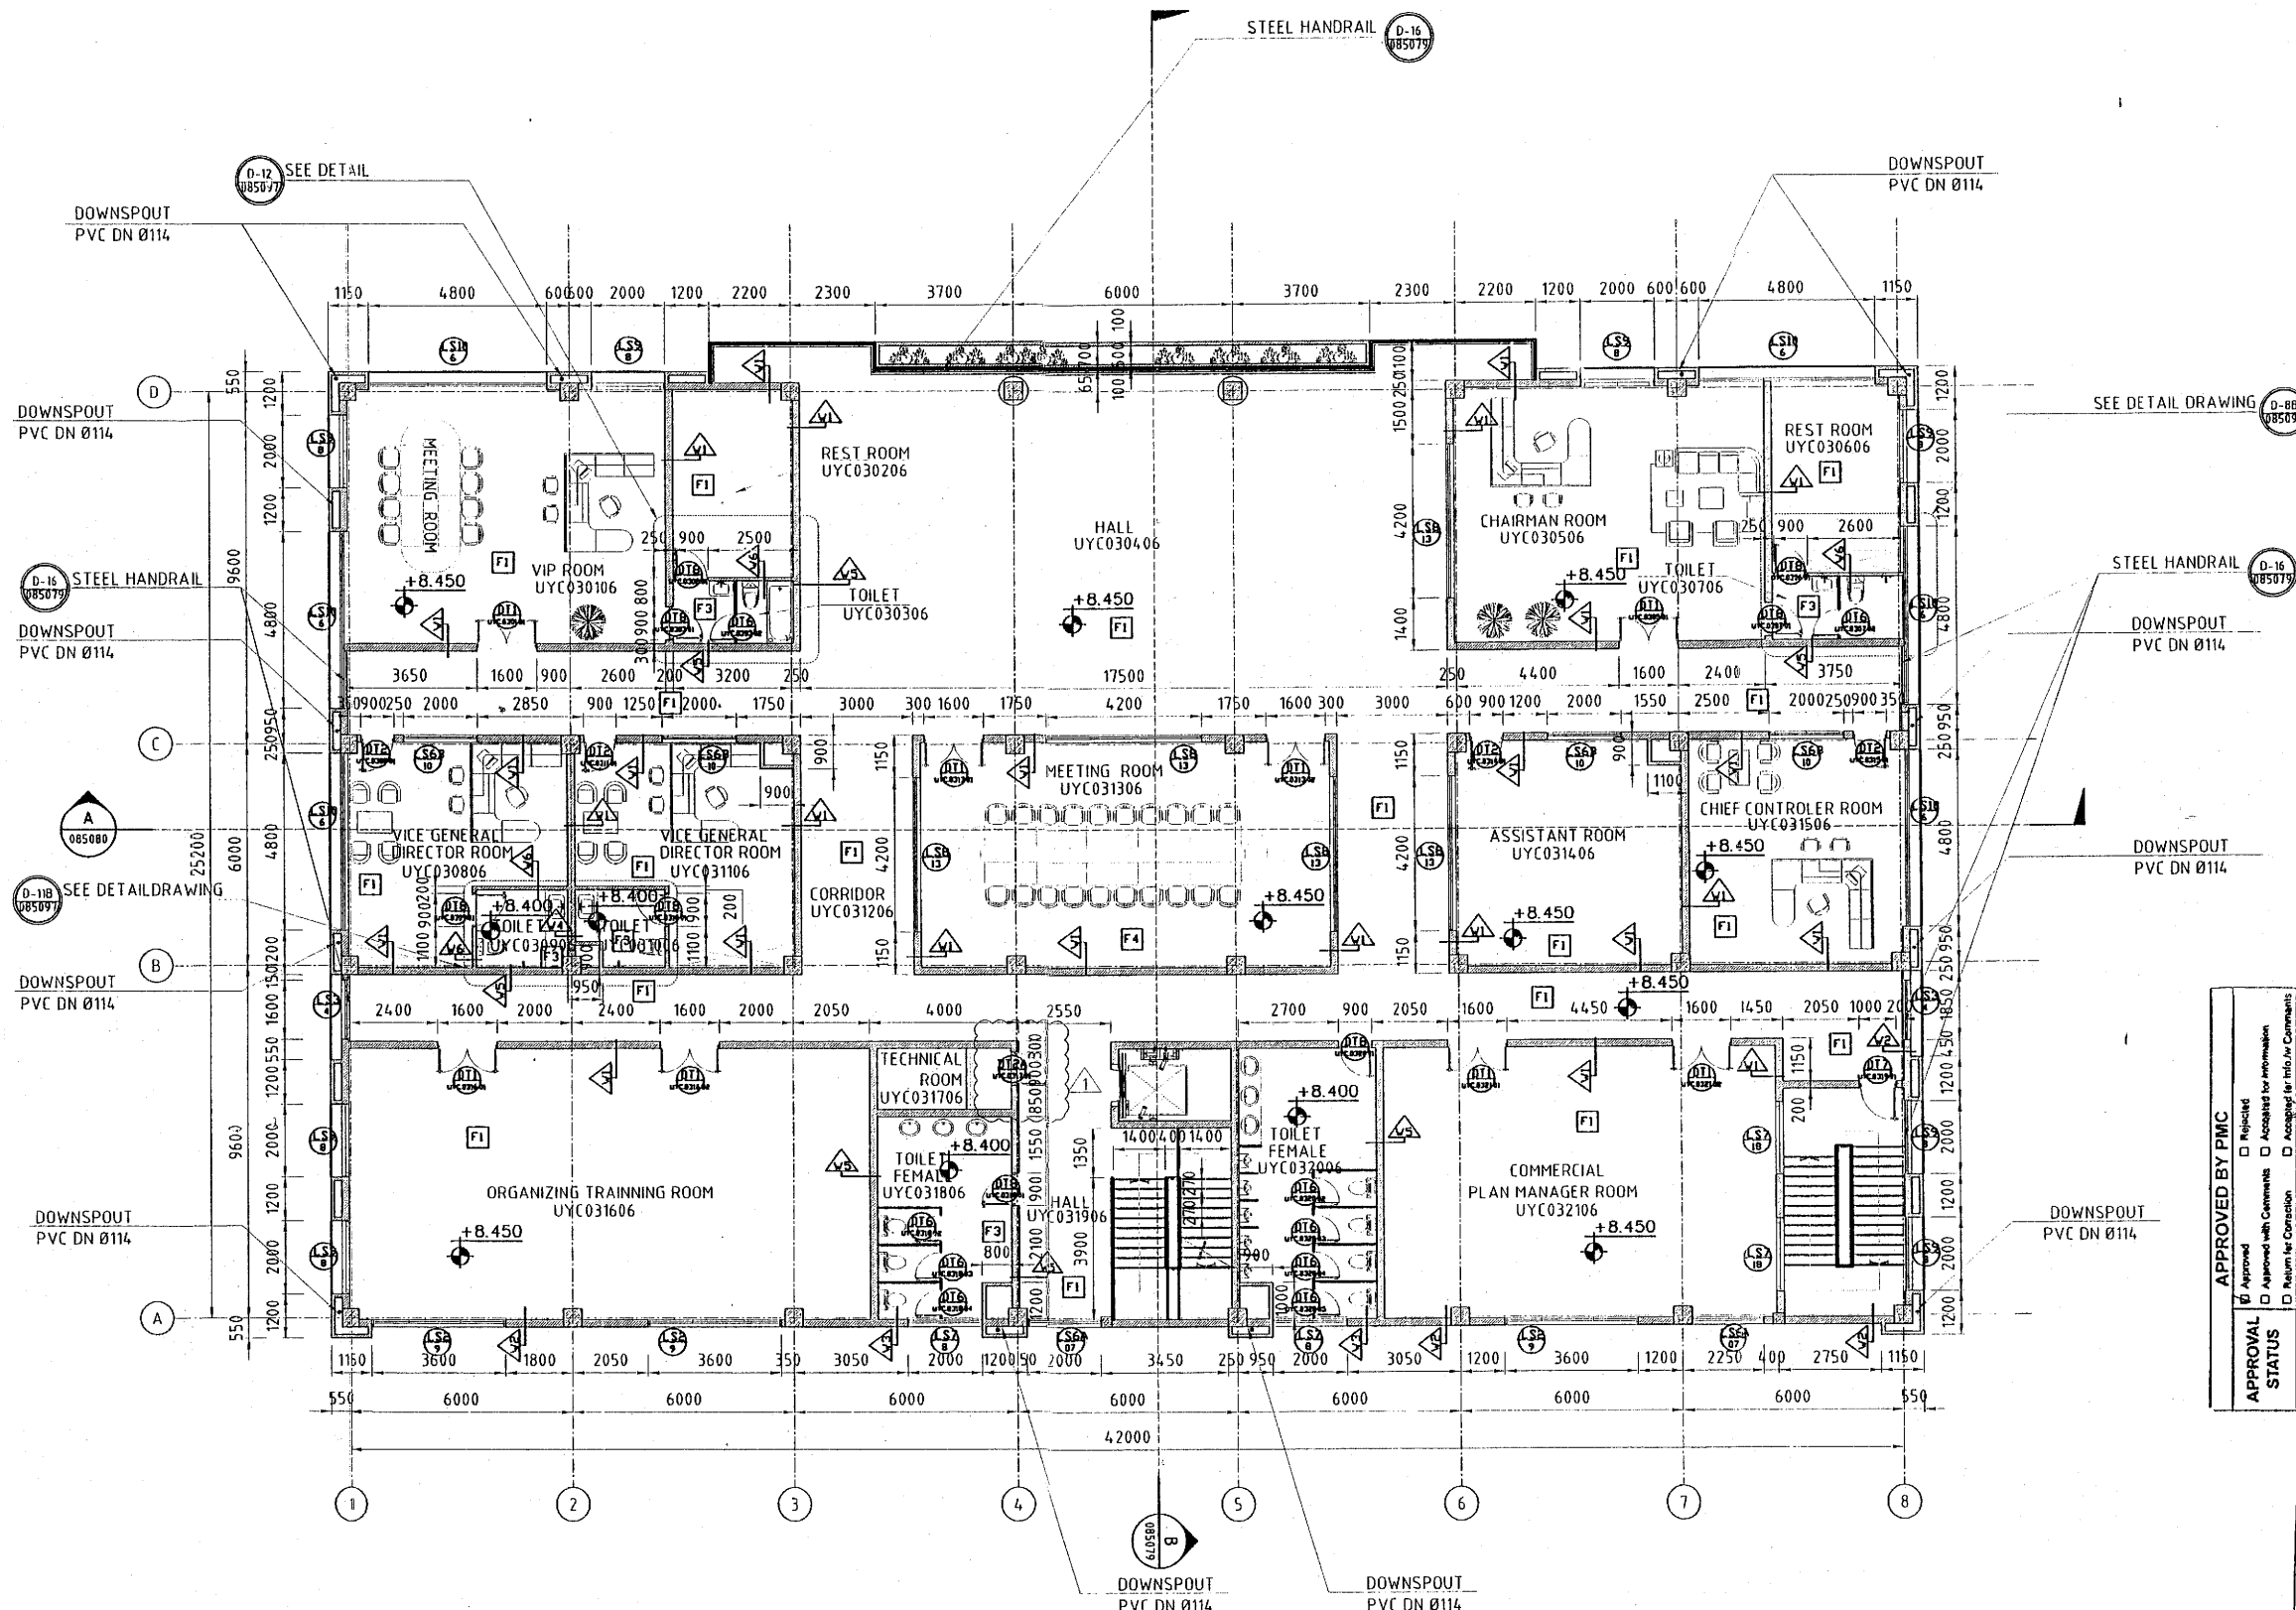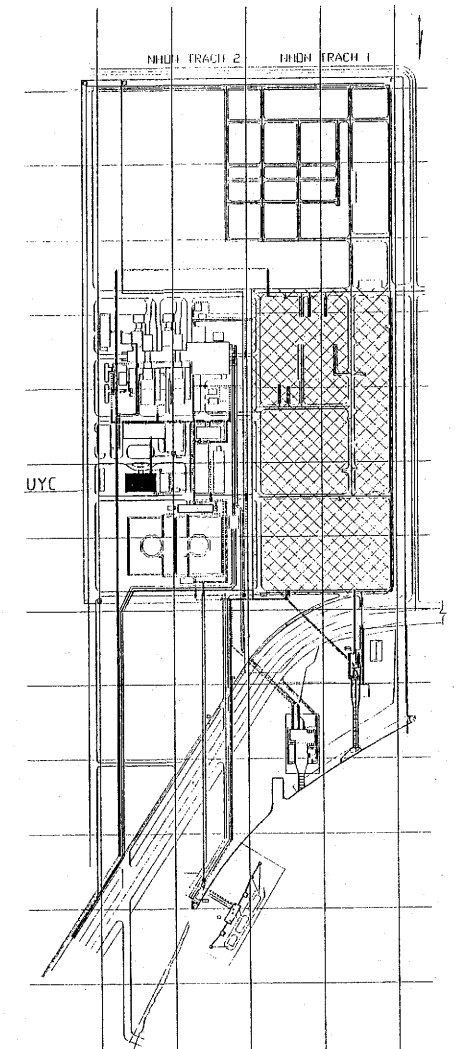

SECOND FLOOR PLAN
1/100

APPROVED BY PMC
APPROVAL STATUS
REVIEWED BY: A. SIEWICKI
PROJECT MANAGER: [Signature]
Date: 13 OCT 2010

APPROVED FOR CONSTRUCTION BY PVC NT2-PMB
Approved by: Name B.Q. CUONG Sign [Signature] Date 22 SEP 2010
Discipline Engineer MARTIN REID
Engineering Manager N.H. HIEU
Project Manager [Signature]

REV.	DATE	DESCRIPTION	DESIGN	CHKD	APPD
1	28-08-10	FOR CONSTRUCTION	NAT	NCC	TJ
0	21-07-10	FOR CONSTRUCTION	NAT	NCC	TJ
C	14-04-10	FOR APPROVAL	NAT	NCC	TJ
B	26-03-10	FOR APPROVAL GENERAL LAYOUT	NAT	NCC	TJ
A	05-03-10	FOR APPROVAL GENERAL LAYOUT	NAT	NCC	TJ

PROJECT: NHON TRACH 2 - 750MW COMBINED CYCLE POWER PLANT PROJECT

OWNER: PETRO VIETNAM
NHON TRACH 2 POWER
JOINT STOCK COMPANY
EPC CONTRACTOR: LILAMA - PVC CONSORTIUM
CONSULTANT: FICHTNER GmbH & Co.KG
CONSULTANT: CONNELL WAGNER (AURECON)

PETRO VIETNAM NHON TRACH 2
POWER JOINT STOCK COMPANY
APPROVED FOR CONSTRUCTION
OWNER: [Signature] Full name: U.N. HAI
Project Manager: [Signature]
Date: 13 OCT 2010

FUNCTION	NAME	SIGN	DATE	FUNCTION	NAME	SIGN	DATE
APPROVED	TJ	[Signature]	28-08-10	CHECKED BY:	CONNELL WAGNER		
CHECKED	NCC	[Signature]	28-08-10				
DRAWN	NAT	[Signature]	28-08-10				

DRAWING NO: NT2-L4-C-UYC.71-085072
DATE: 14-09-10
REV: 1